


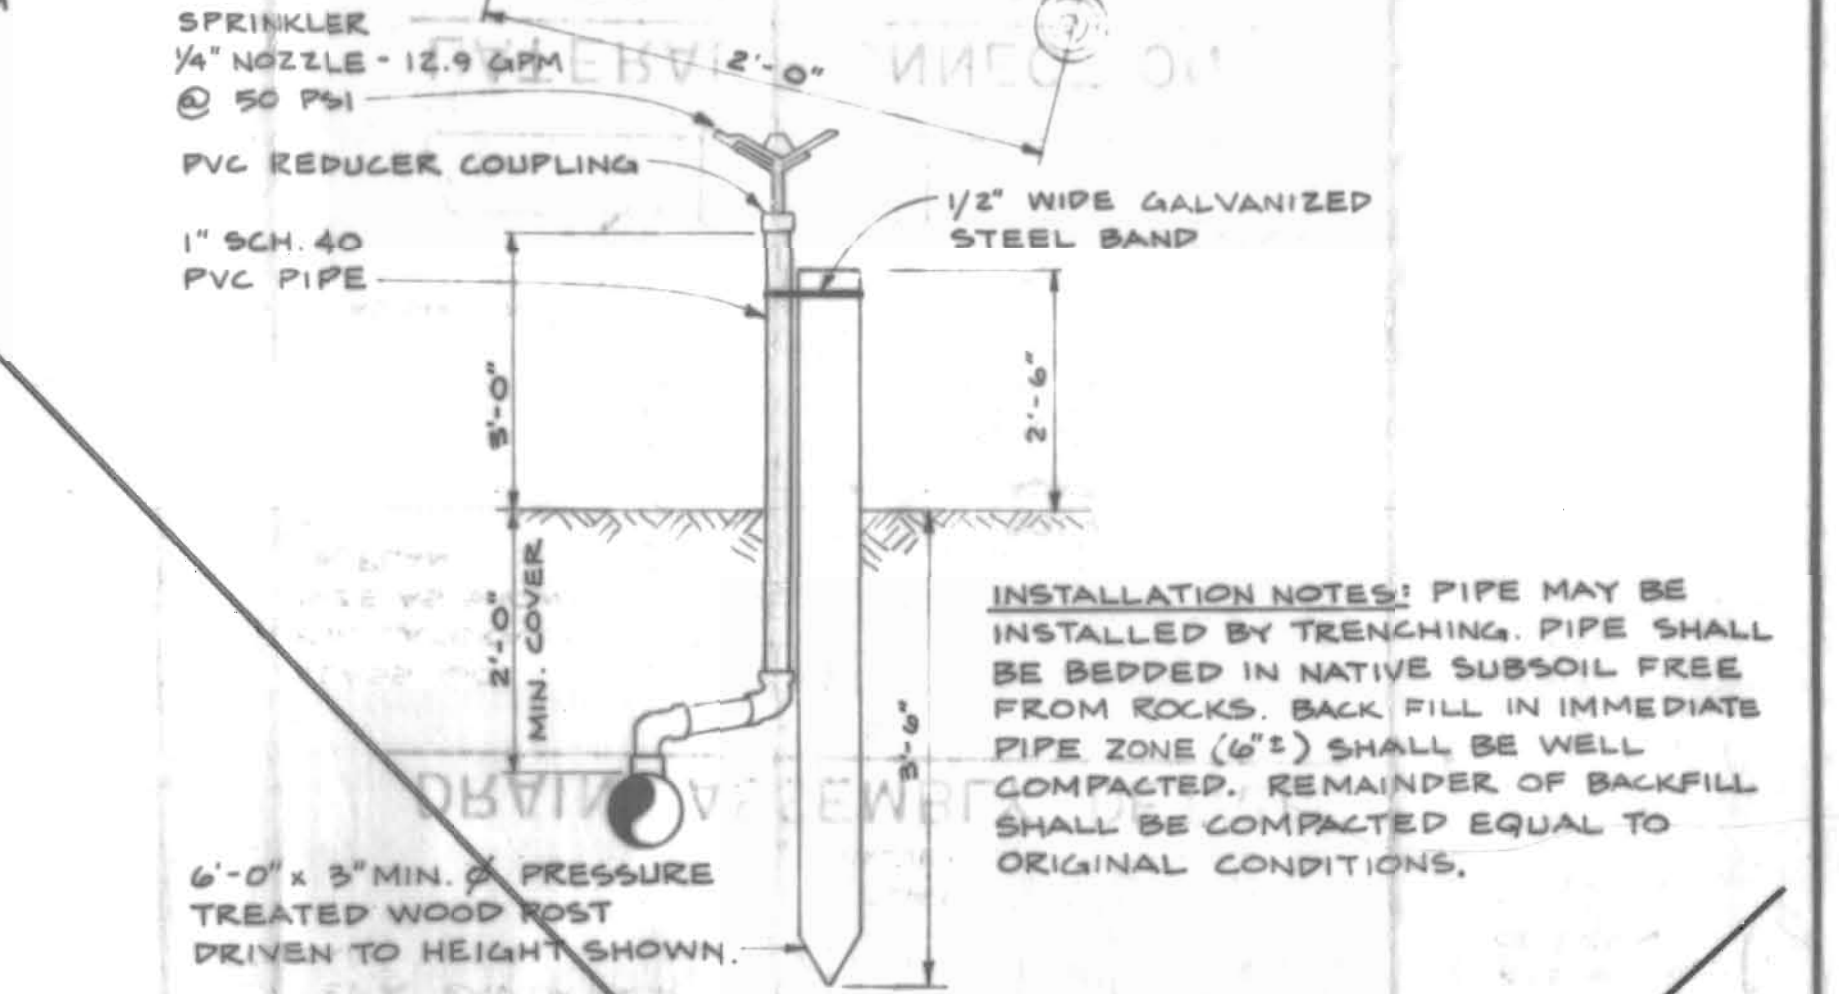
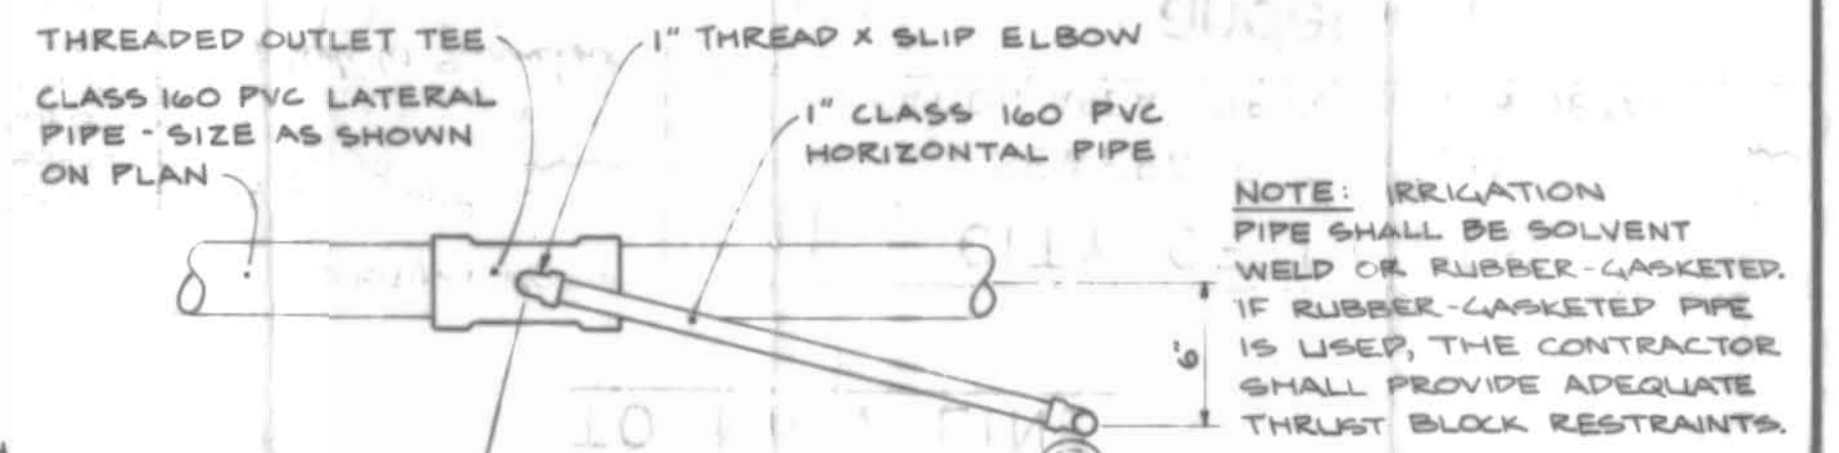


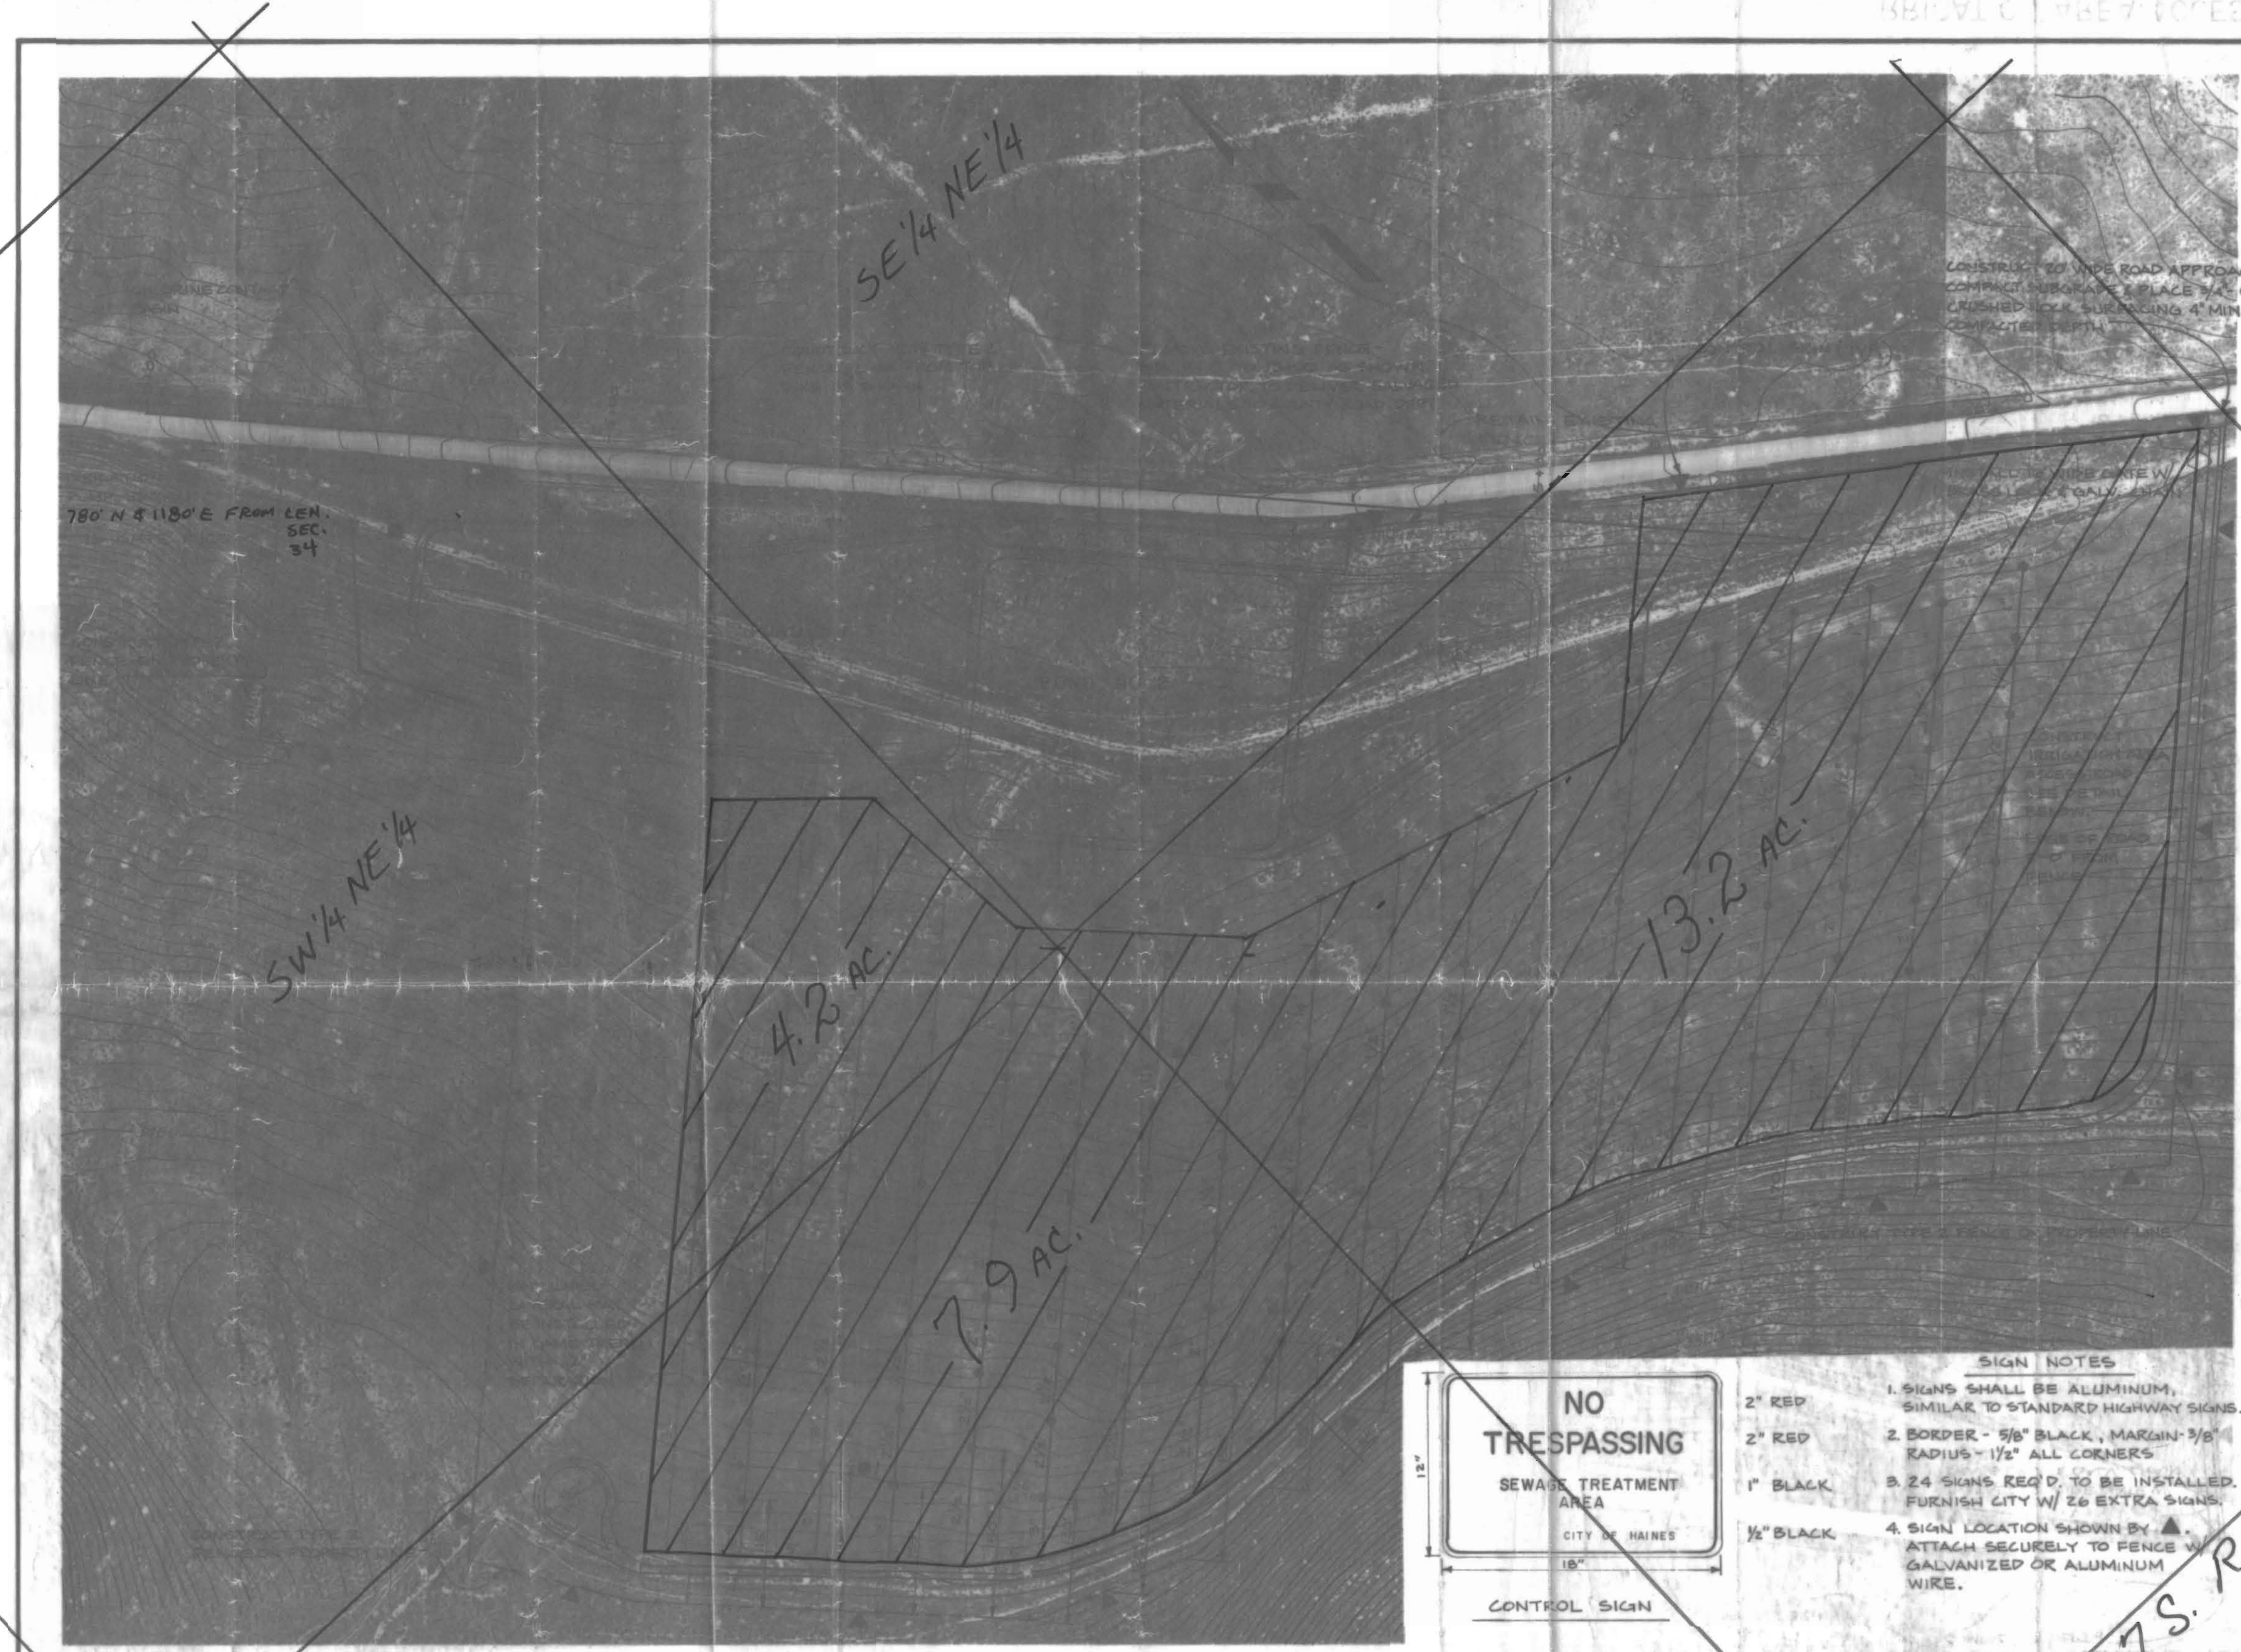

TYPICAL RISER DETAIL
N.T.S.

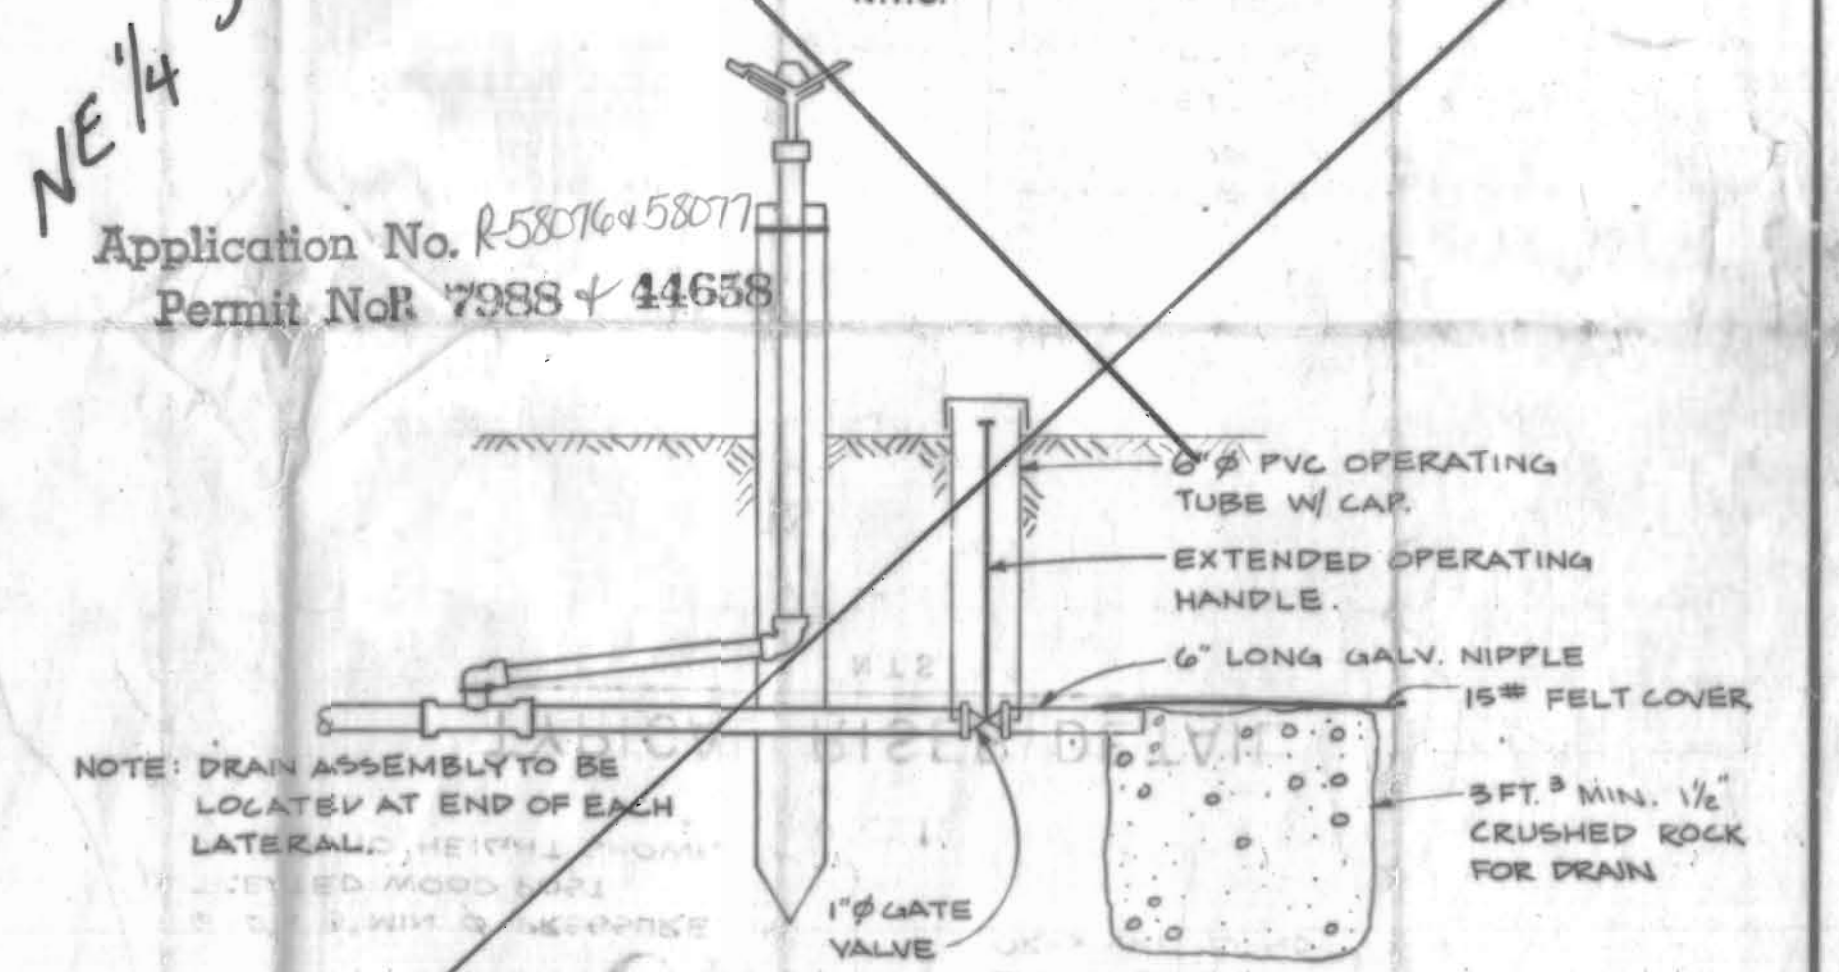






DRAIN ASSEMBLY DETAIL
N.T.S.

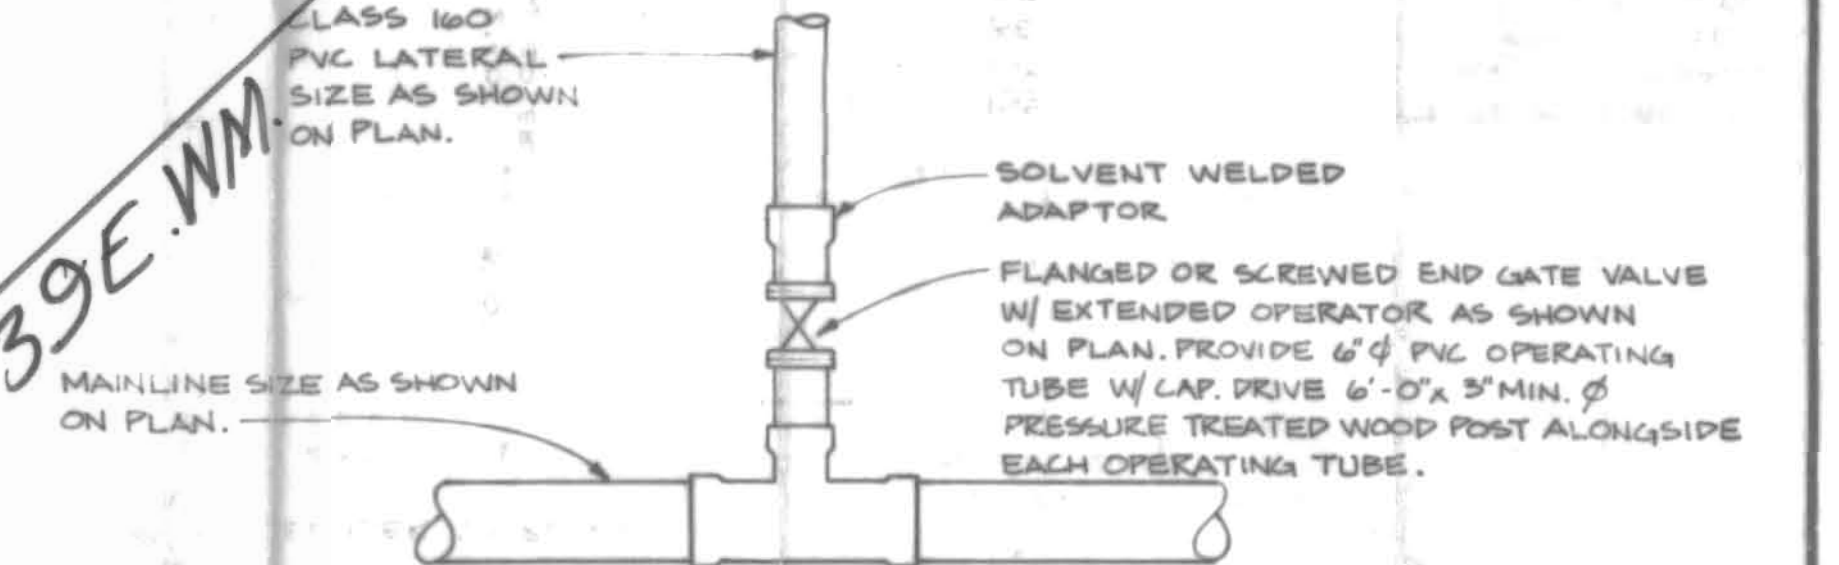

LATERAL CONNECTION TO MAIN LINE
N.T.S.



- SIGN NOTES**
1. SIGNS SHALL BE ALUMINUM, SIMILAR TO STANDARD HIGHWAY SIGNS.
 2. BORDER - 5/8\"/>
 3. 24 SIGNS REQ'D. TO BE INSTALLED. FURNISH CITY W/ 26 EXTRA SIGNS.
 4. SIGN LOCATION SHOWN BY ▲. ATTACH SECURELY TO FENCE W/ GALVANIZED OR ALUMINUM WIRE.

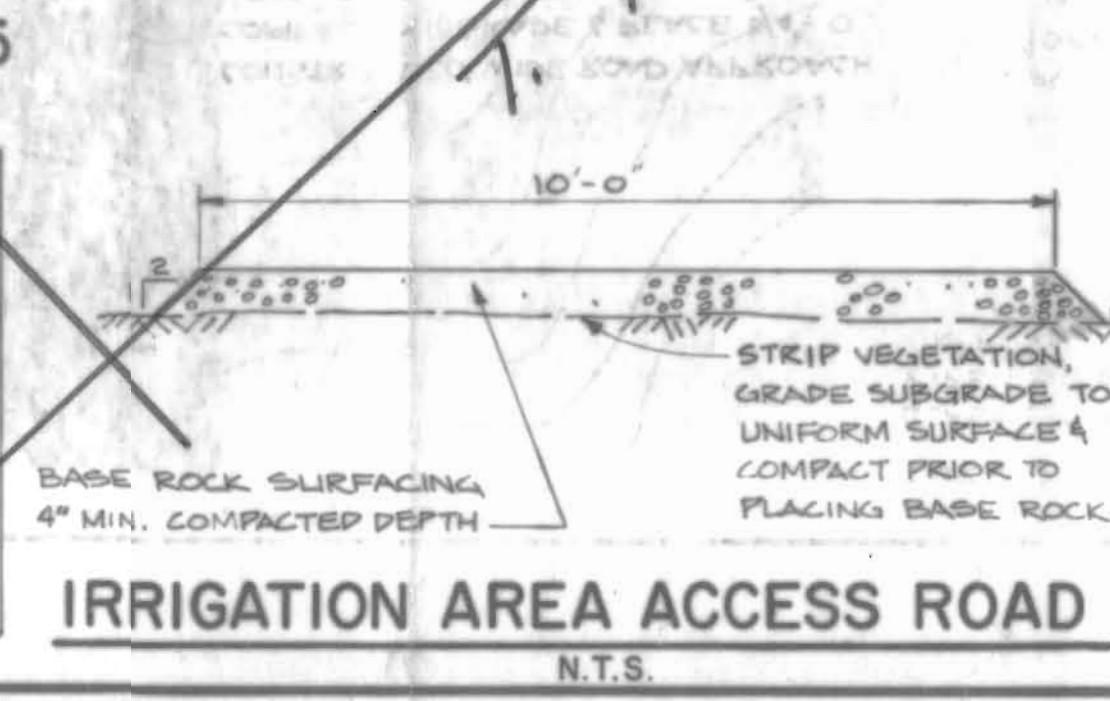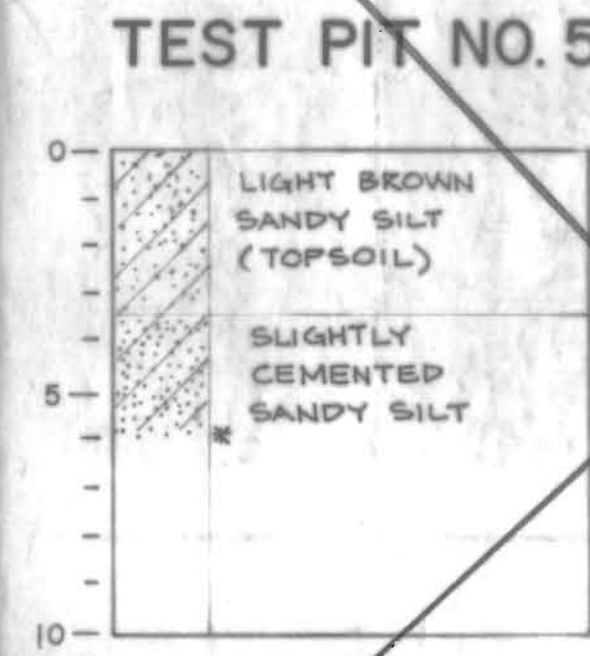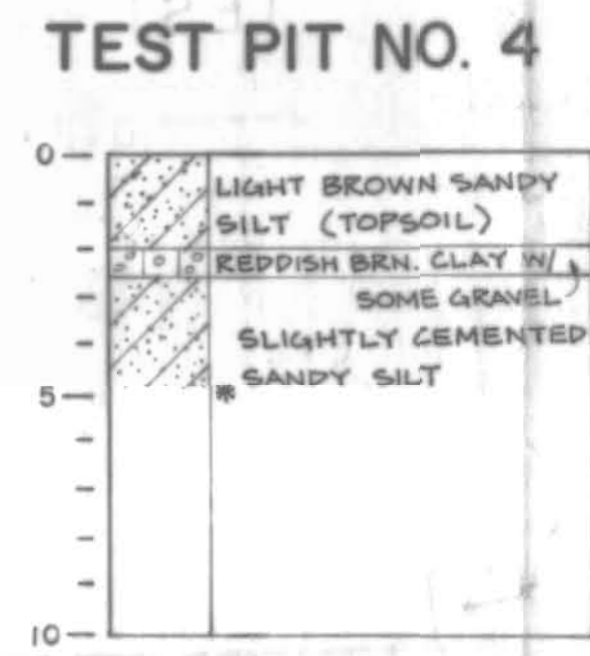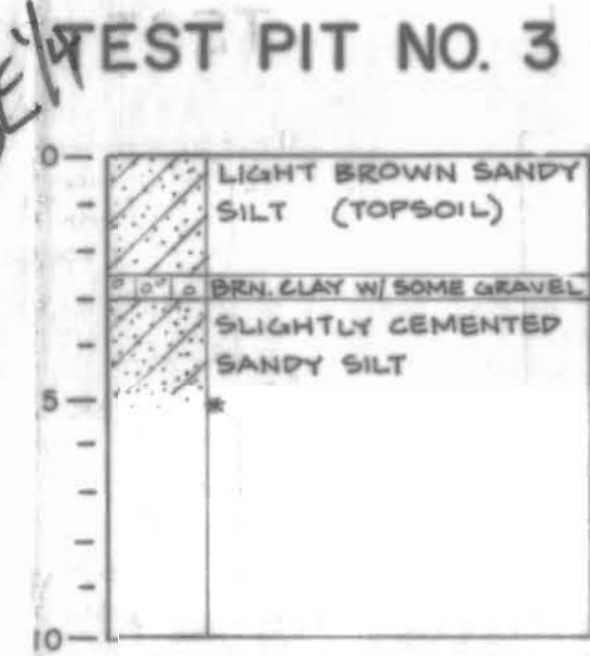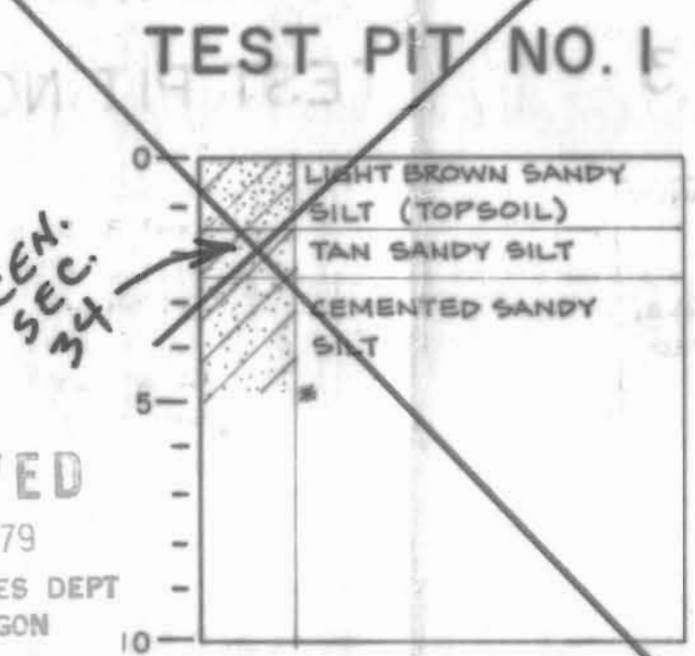

CITY OF HAINES SEWERAGE SYSTEM	
IRRIGATION AREA - PIPING PLAN & DETAILS	
SCALE 1" = 100'	SHEET NO. 35
anderson perly associates, inc. engineers - surveyors - drafters LA GRANDE - ENTERPRISE - OREGON	
DATE 1979	

RECEIVED
DEC 10 1979
WATER RESOURCES DEPT
SALEM, OREGON