
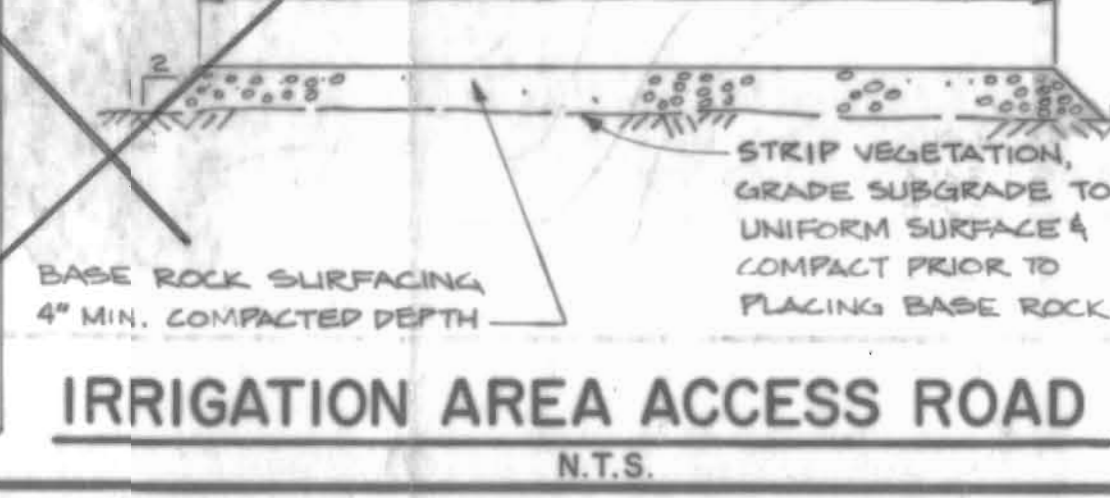
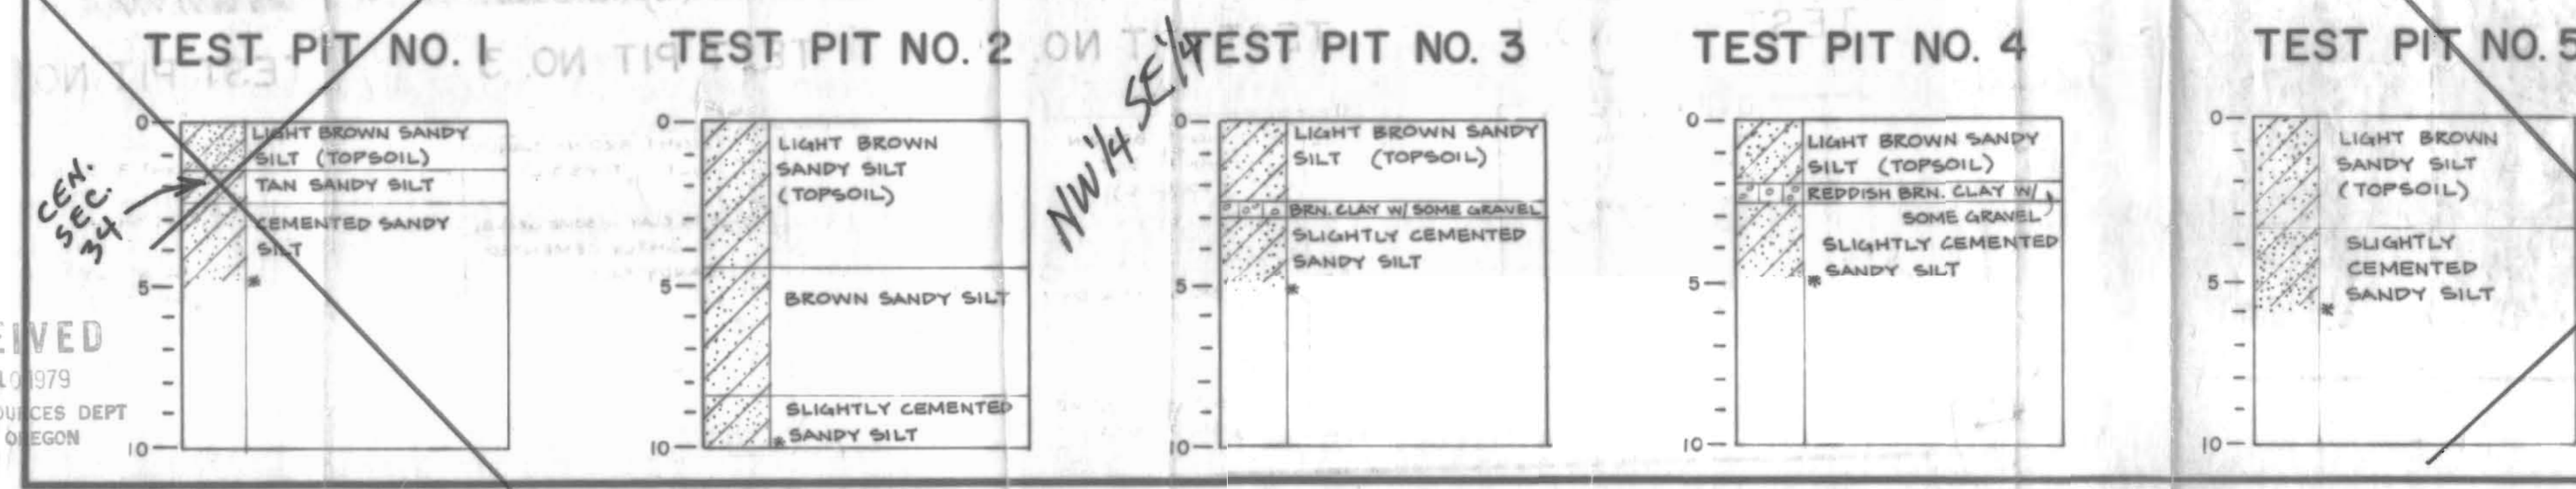
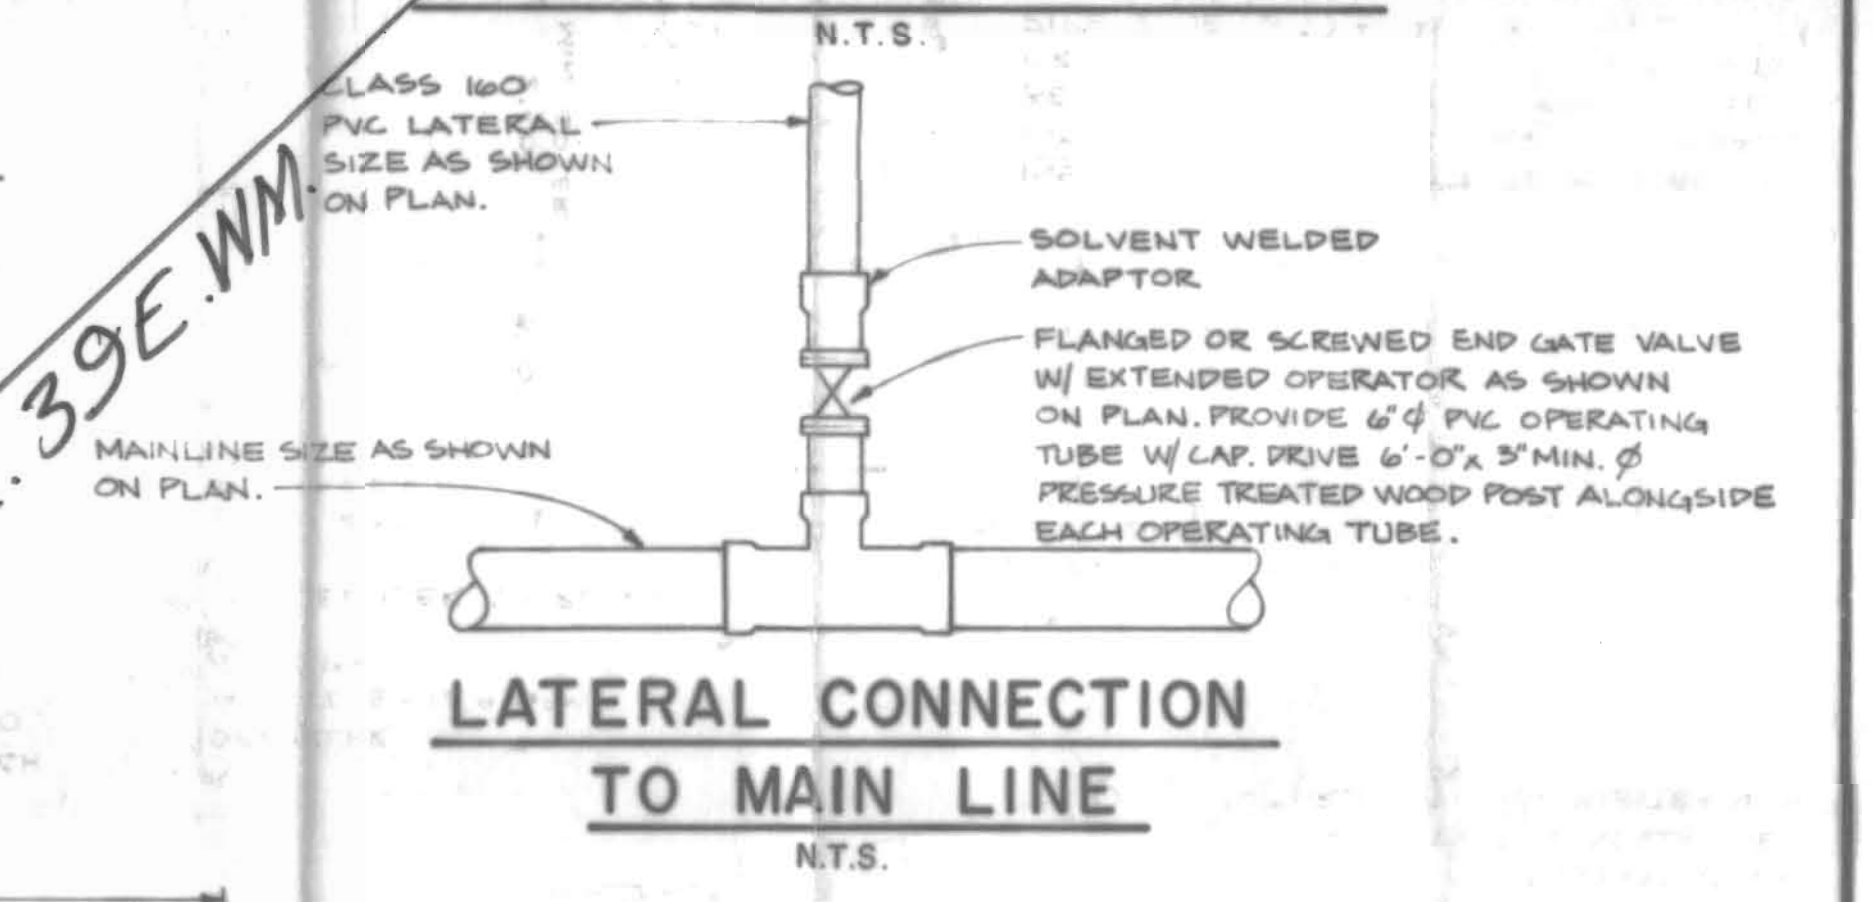
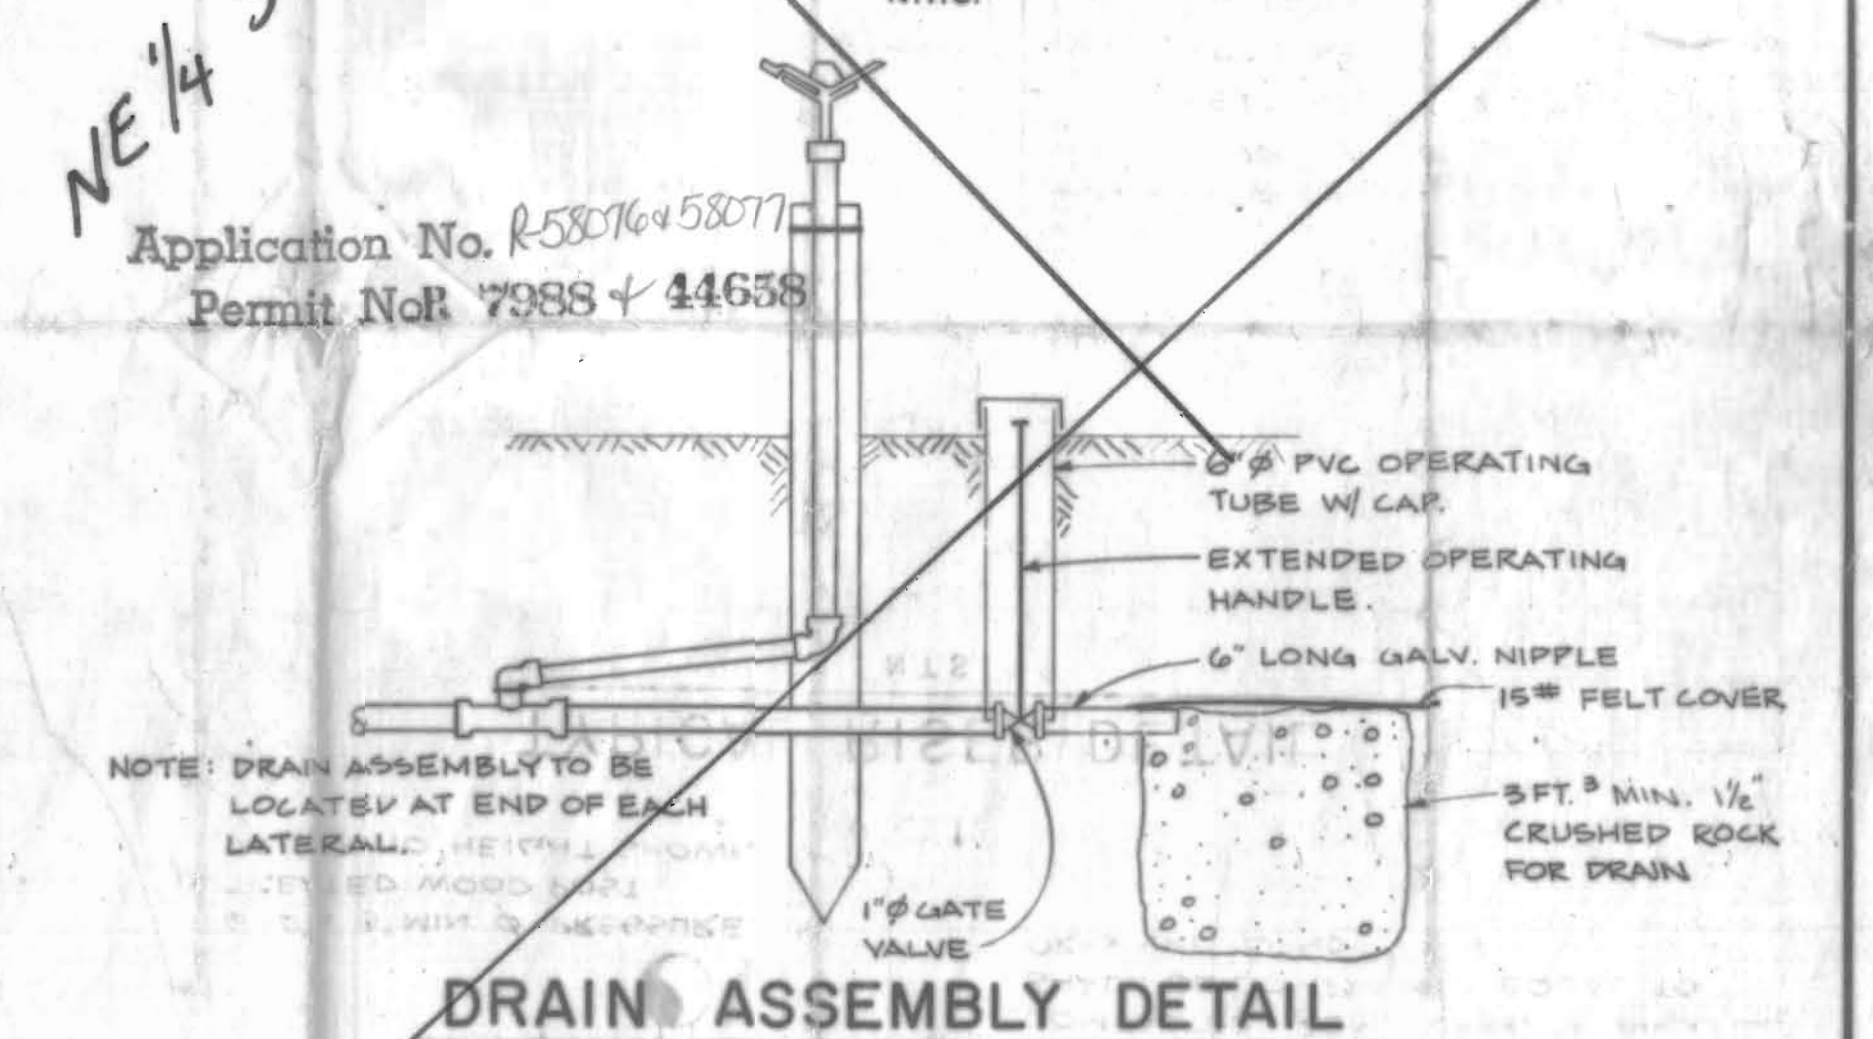


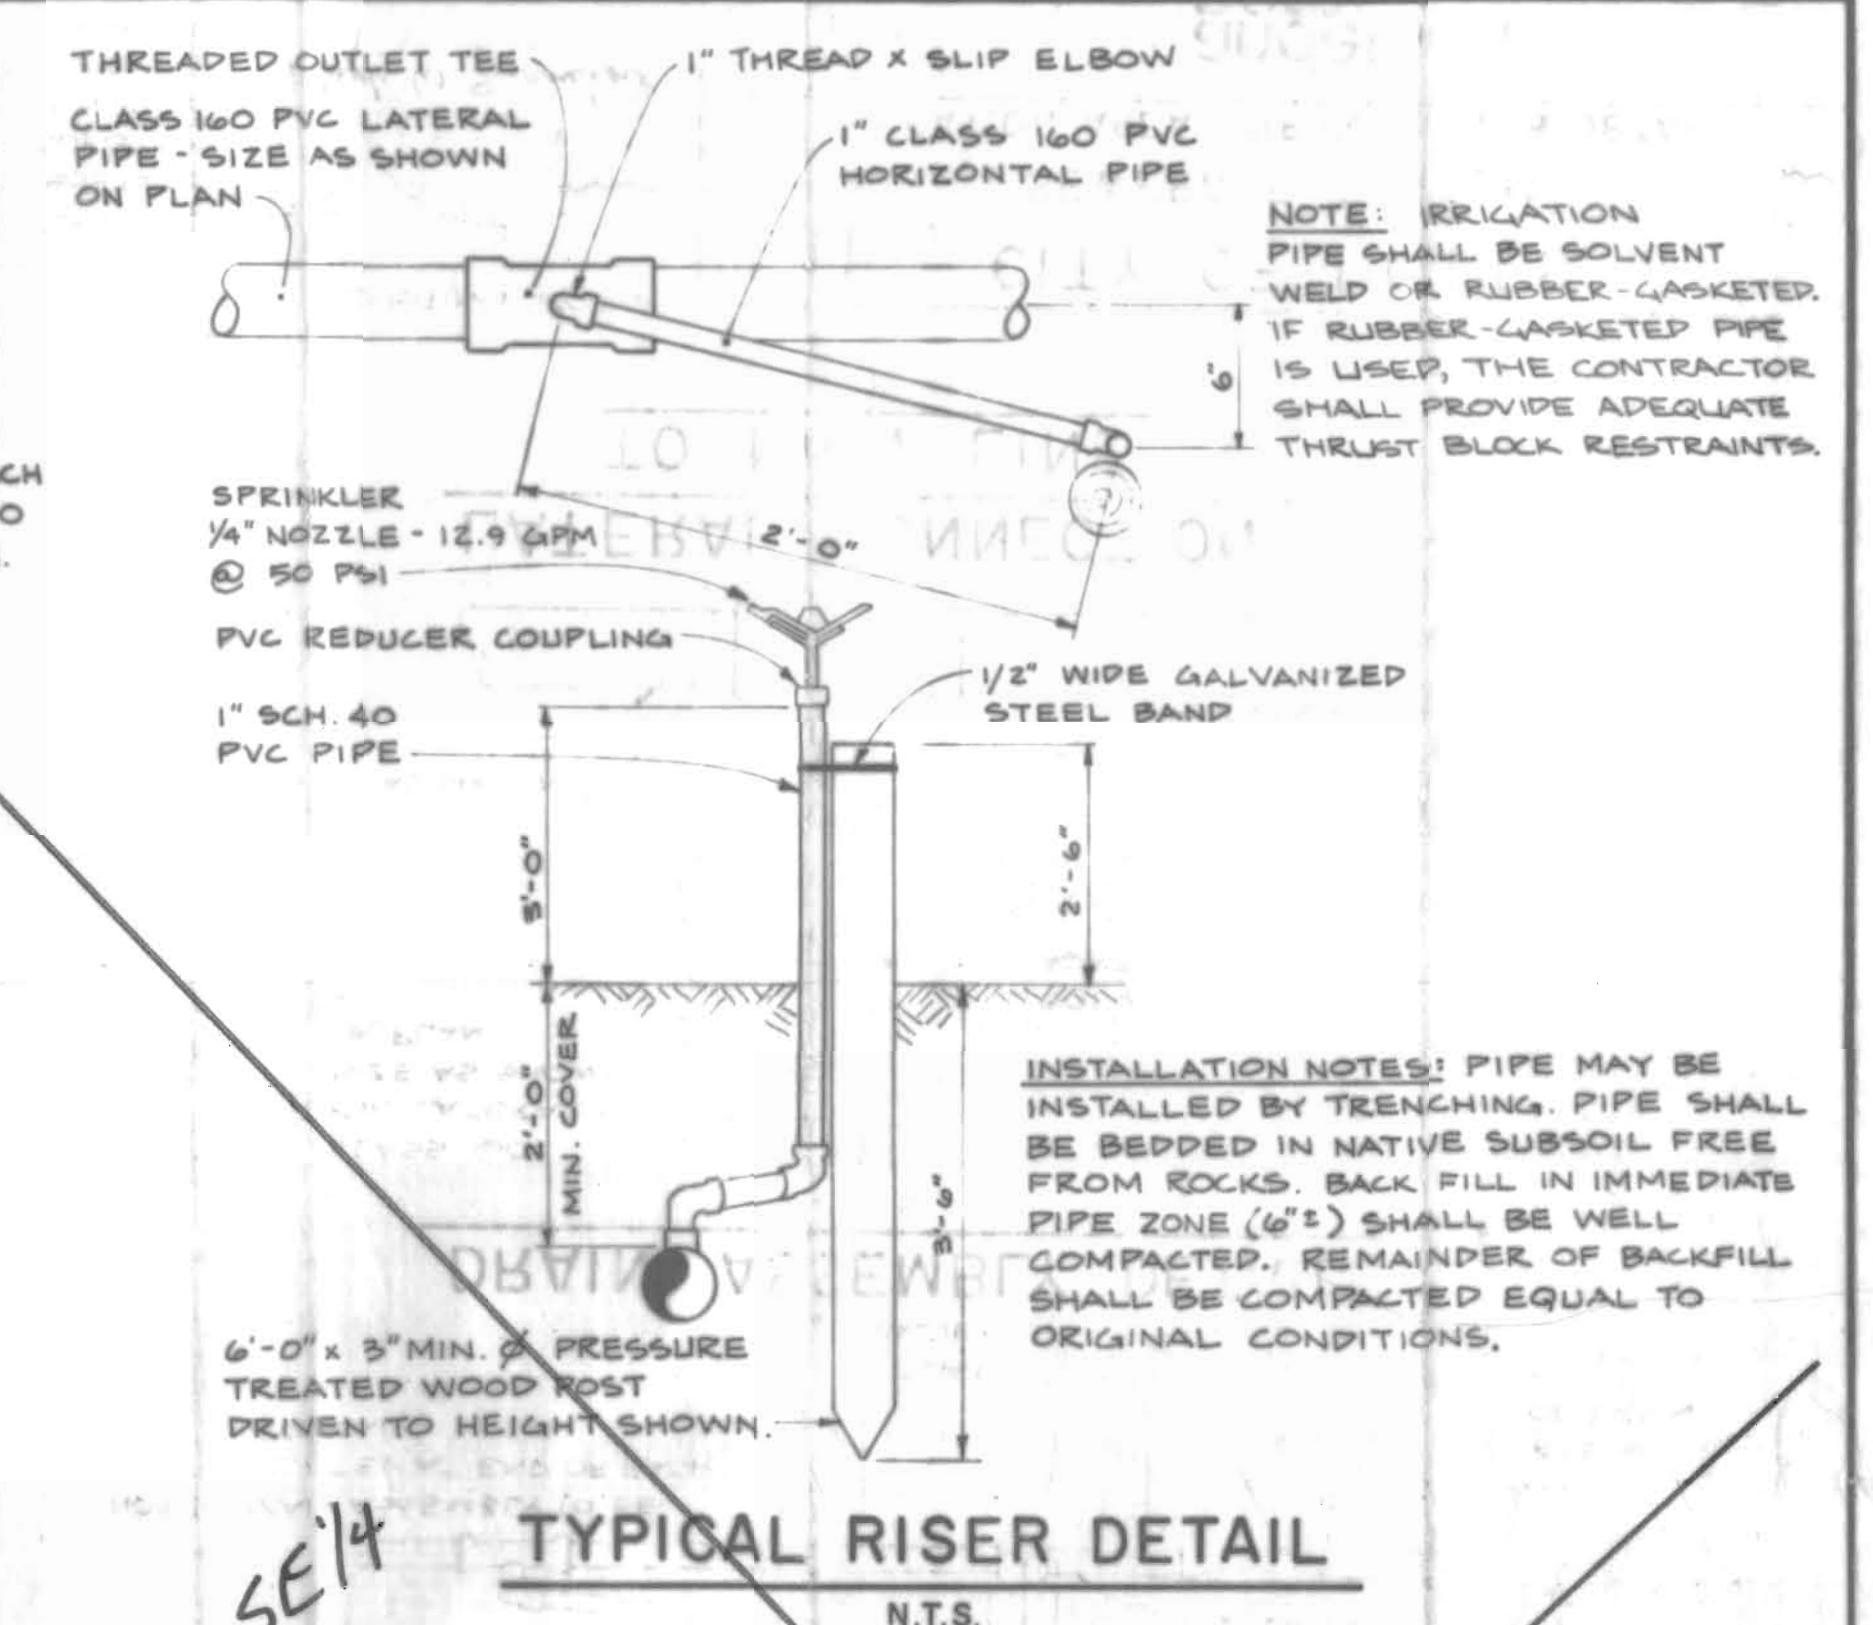

CITY OF HAINES
SEWERAGE SYSTEM
IRRIGATION AREA - PIPING PLAN & DETAILS

SCALE: 1" = 100'
DATE: 1979

anderson perry
associates, inc.
engineers - surveyors - drafters
LA GRANDE - ENTERPRISE - OREGON

35

REGISTERED PROFESSIONAL ENGINEER
8526
PETER W. SWINERT
OREGON
SINCE 1978

RECEIVED
DEC 10 1979
WATER RESOURCES DEPT
SALEM, OREGON